

 


- KEY NOTES:**
- (E) ROLL-UP FIRE DOOR, CONNECT TO NEW SYSTEM.
 - FIRE/SMOKE DAMPER IN (E) DUCTWORK. CONNECT TO NEW SYSTEM.
 - (E) FIRE ALARM PANEL.
 - NEW FIRE ALARM PANEL.
 - (E) ANNUNCIATOR PANEL LOCATION. PROVIDE NEW IN SAME LOCATION.
 - CONNECT TO DOOR HOLD-OPEN DEVICES AT ELEVATORS

- SHEET NOTES:**
- APPROXIMATE LAYOUT OF EXISTING FIRE ALARM SYSTEM IS SHOWN ON THIS SHEET, PLUS ADDITIONAL DEVICES.
 - PROVIDE DUCT SMOKE DETECTORS AS REQUIRED IN DUCTWORK FROM AIR HANDLING EQUIPMENT AND CONNECT TO FIRE ALARM SYSTEM.
 - DRAWINGS WERE PREPARED FROM PREVIOUS PROJECT DOCUMENTS AND SITE OBSERVATIONS, AND MAY NOT BE AN ACCURATE AS-BUILT CONDITION. CONTRACTOR TO VERIFY BEFORE BEGINNING WORK.



LEVEL ONE FIRE ALARM SYSTEM
SCALE: 1/8" = 1'-0"



DESIGNED:	SCS
	DRAWN:
DATE:	1/28/2021

RICHMOND
ENGINEERING LLC
3721 GRIFFIN LANE SOUTHEAST
OLYMPIA, WA 98501
360.956.0364
WWW.RICHMONDSYSTEMS.COM

PREPARED BY:

REVISION	BY	DATE	OK'D

SHEET CONTENTS:

LEVEL ONE FIRE ALARM SYSTEM AS BUILT

TITLE:

**LEWIS COUNTY
COURTHOUSE FIRE ALARM SYSTEM**


CHEHALIS, WA 98532

PROJECT NO.:

5623

SHEET:

FA5.1

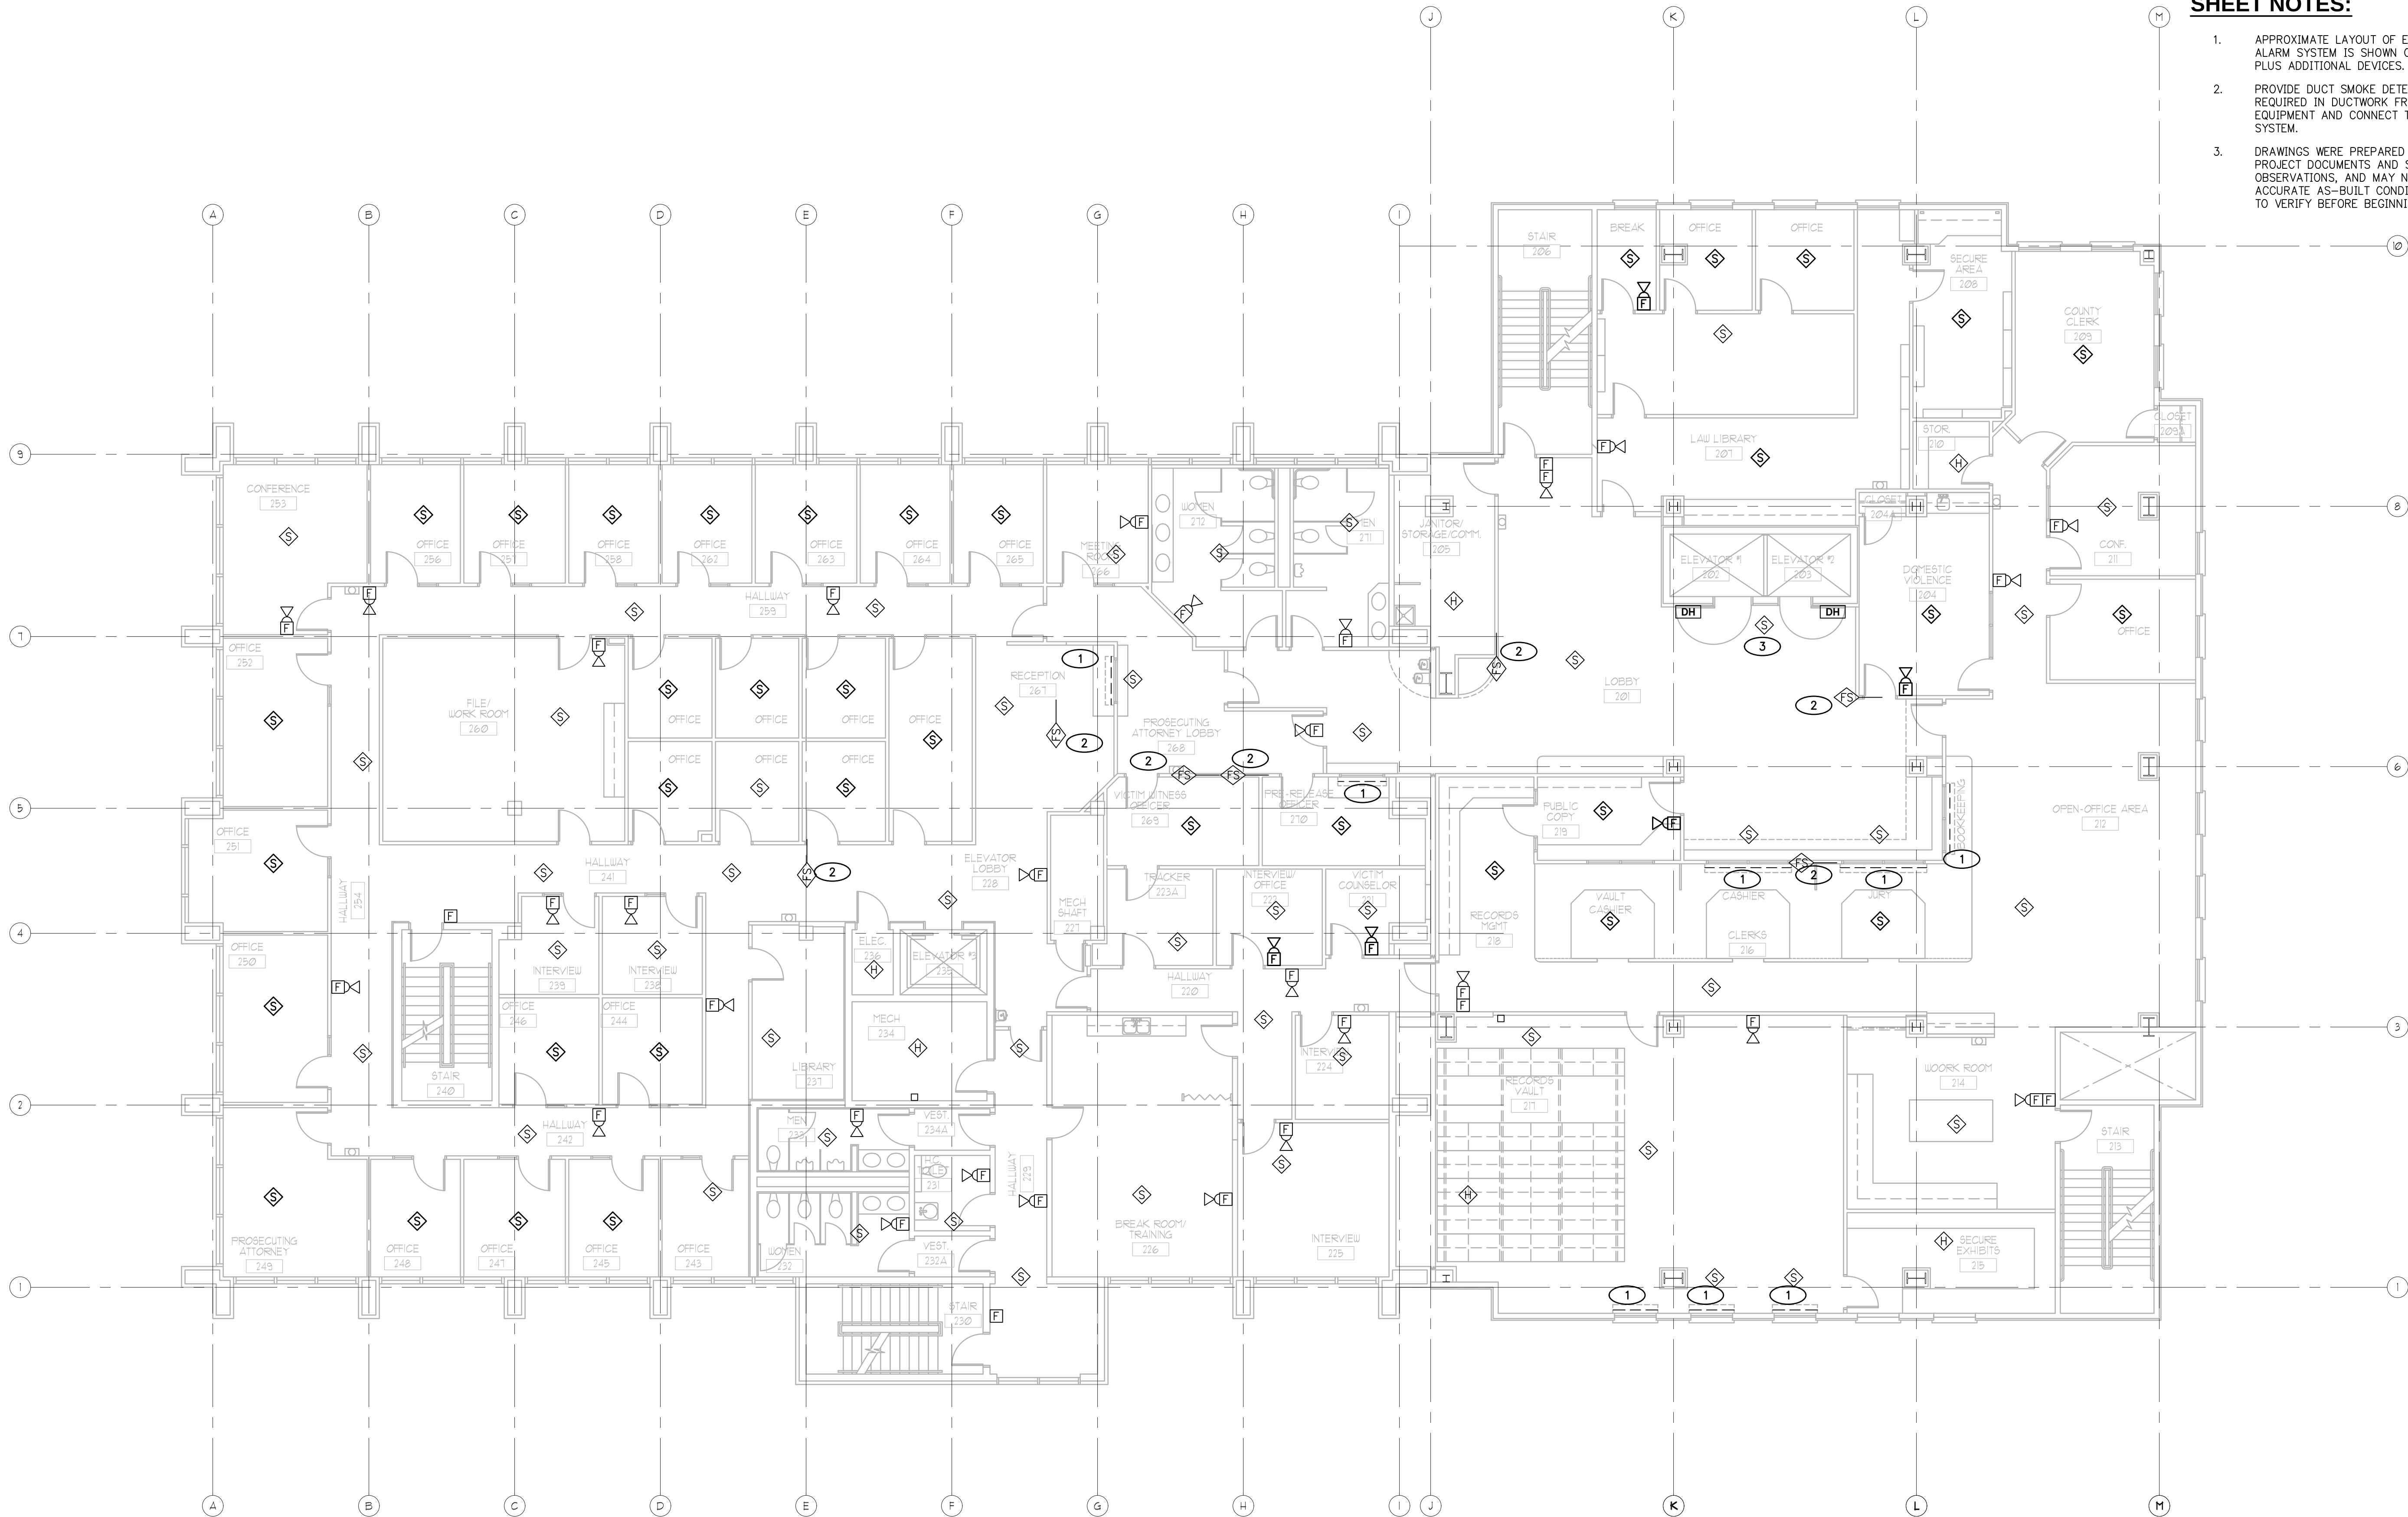


- KEY NOTES:**
- (E) ROLL-UP FIRE DOOR, CONNECT TO NEW SYSTEM
 - FIRE/SMOKE DAMPER IN (E) DUCTWORK. CONNECT TO NEW SYSTEM
 - CONNECT TO DOOR HOLD-OPEN DEVICES AT ELEVATORS

- SHEET NOTES:**
- APPROXIMATE LAYOUT OF EXISTING FIRE ALARM SYSTEM IS SHOWN ON THIS SHEET, PLUS ADDITIONAL DEVICES.
 - PROVIDE DUCT SMOKE DETECTORS AS REQUIRED IN DUCTWORK FROM AIR HANDLING EQUIPMENT AND CONNECT TO FIRE ALARM SYSTEM.
 - DRAWINGS WERE PREPARED FROM PREVIOUS PROJECT DOCUMENTS AND SITE OBSERVATIONS, AND MAY NOT BE AN ACCURATE AS-BUILT CONDITION. CONTRACTOR TO VERIFY BEFORE BEGINNING WORK.



LEVEL TWO FIRE ALARM SYSTEM

 SCALE: 1/8" = 1'-0"



DESIGNED:	SCS
DRAWN:	TMP
DATE:	1/28/2021

RICHMOND ENGINEERING LLC
9721 GRIFFIN LANE SOUTHEAST
OLYMPIA, WA 98501
360.956.0364
WWW.RICHMONDSYSTEMS.COM

PREPARED BY:

GEORGE M. RICHMOND
STATE OF WASHINGTON
REGISTERED PROFESSIONAL ENGINEER
20810


REVISION	DATE	BY	OK'D

SHEET CONTENTS:
LEVEL TWO FIRE ALARM SYSTEM AS BUILT

TITLE:
LEWIS COUNTY COURTHOUSE FIRE ALARM SYSTEM
CHEHALIS, WA 98532

PROJECT NO.:
5623

SHEET:
FA5.2

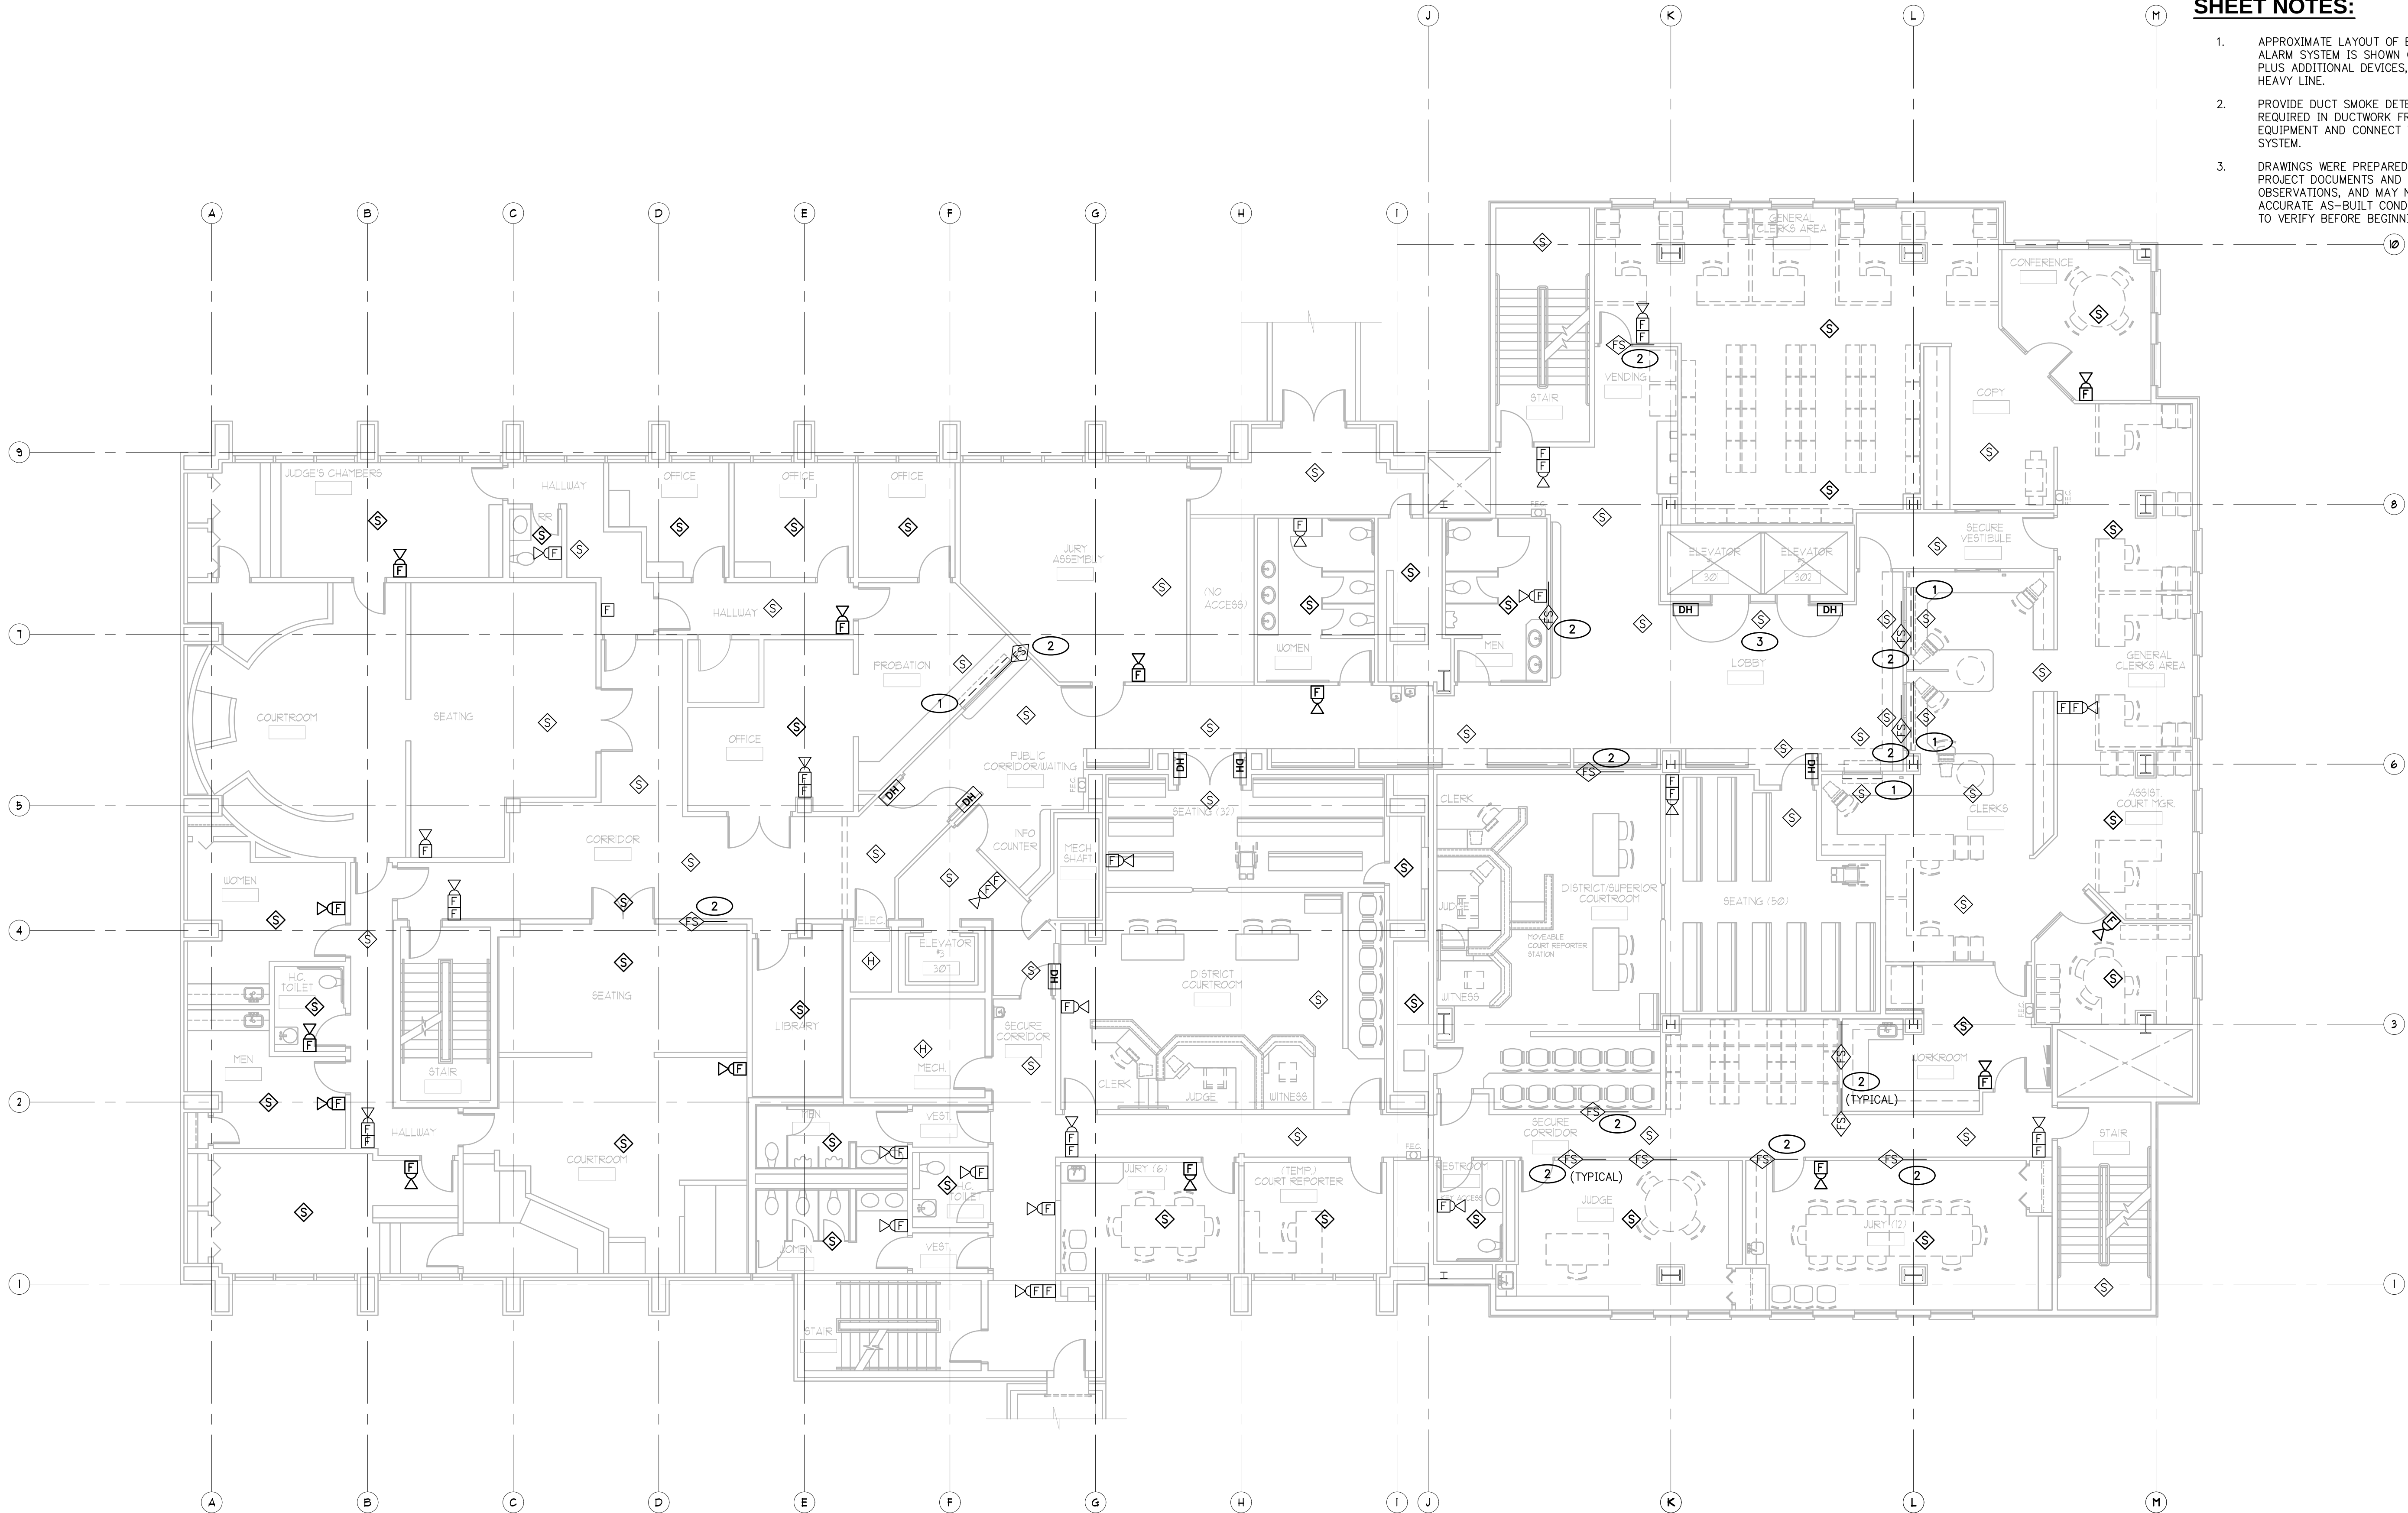


- KEY NOTES:**
- 1 (E) ROLL-UP FIRE DOOR, CONNECT TO NEW SYSTEM.
 - 2 FIRE/SMOKE DAMPER IN (E) DUCTWORK. CONNECT TO NEW SYSTEM
 - 3 CONNECT TO DOOR HOLD-OPEN DEVICES AT ELEVATORS


- SHEET NOTES:**
- 1. APPROXIMATE LAYOUT OF EXISTING FIRE ALARM SYSTEM IS SHOWN ON THIS SHEET, PLUS ADDITIONAL DEVICES, INDICATED WITH HEAVY LINE.
 - 2. PROVIDE DUCT SMOKE DETECTORS AS REQUIRED IN DUCTWORK FROM AIR HANDLING EQUIPMENT AND CONNECT TO FIRE ALARM SYSTEM.
 - 3. DRAWINGS WERE PREPARED FROM PREVIOUS PROJECT DOCUMENTS AND SITE OBSERVATIONS, AND MAY NOT BE AN ACCURATE AS-BUILT CONDITION. CONTRACTOR TO VERIFY BEFORE BEGINNING WORK.



 LEVEL THREE FIRE ALARM SYSTEM
SCALE: 1/8" = 1'-0"



DESIGNED:	SCS	DRAWN:	TMP	DATE:	1/28/2021
RICHMOND ENGINEERING LLC 9721 GRIFFIN LANE SOUTHEAST OLYMPIA, WA 98501 360.956.0364 WWW.RICHMONDSYSTEMS.COM					
PREPARED BY:					
SHEET CONTENTS:		REVISION			
LEVEL THREE FIRE ALARM SYSTEM AS BUILT					
TITLE:					
LEWIS COUNTY COURTHOUSE FIRE ALARM SYSTEM					
PROJECT NO.: 5623					
SHEET: FA5.3					
DRAWINGS ARE FULL SIZE AT 24X36. SCALE IS INDICATED ON DRAWING.					

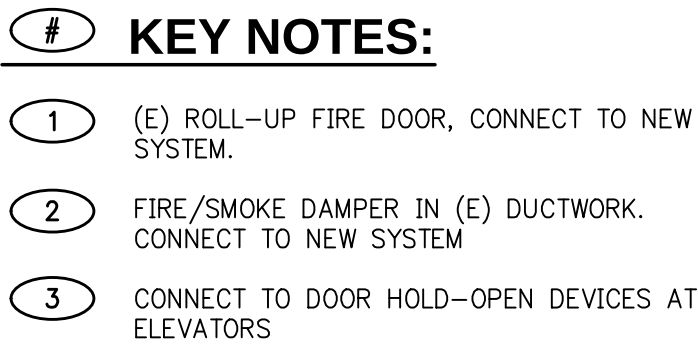

1. APPROXIMATE LAYOUT OF EXISTING FIRE ALARM SYSTEM IS SHOWN ON THIS SHEET, PLUS ADDITIONAL DEVICES.
2. PROVIDE DUCT SMOKE DETECTORS AS REQUIRED IN DUCTWORK FROM AIR HANDLING EQUIPMENT AND CONNECT TO FIRE ALARM SYSTEM.
3. DRAWINGS WERE PREPARED FROM PREVIOUS PROJECT DOCUMENTS AND SITE OBSERVATIONS, AND MAY NOT BE AN ACCURATE AS-BUILT CONDITION. CONTRACTOR TO VERIFY BEFORE BEGINNING WORK.

DESIGNED: _____


PREPARED BY: _____

[illegible]

SHEET CONTENTS:	LEVEL FOUR FIRE ALARM SYSTEM AS BUILT
TITLE:	LEWIS COUNTY COURTHOUSE FIRE ALARM SYSTEM
	CHEHALIS, WA 98532

PROJECT NO.: 5623	SHEET: FA5.4
----------------------	------------------------

DRAWINGS ARE FULL SIZE AT 24X36
SCALE IS INDICATED ON DRAWING.

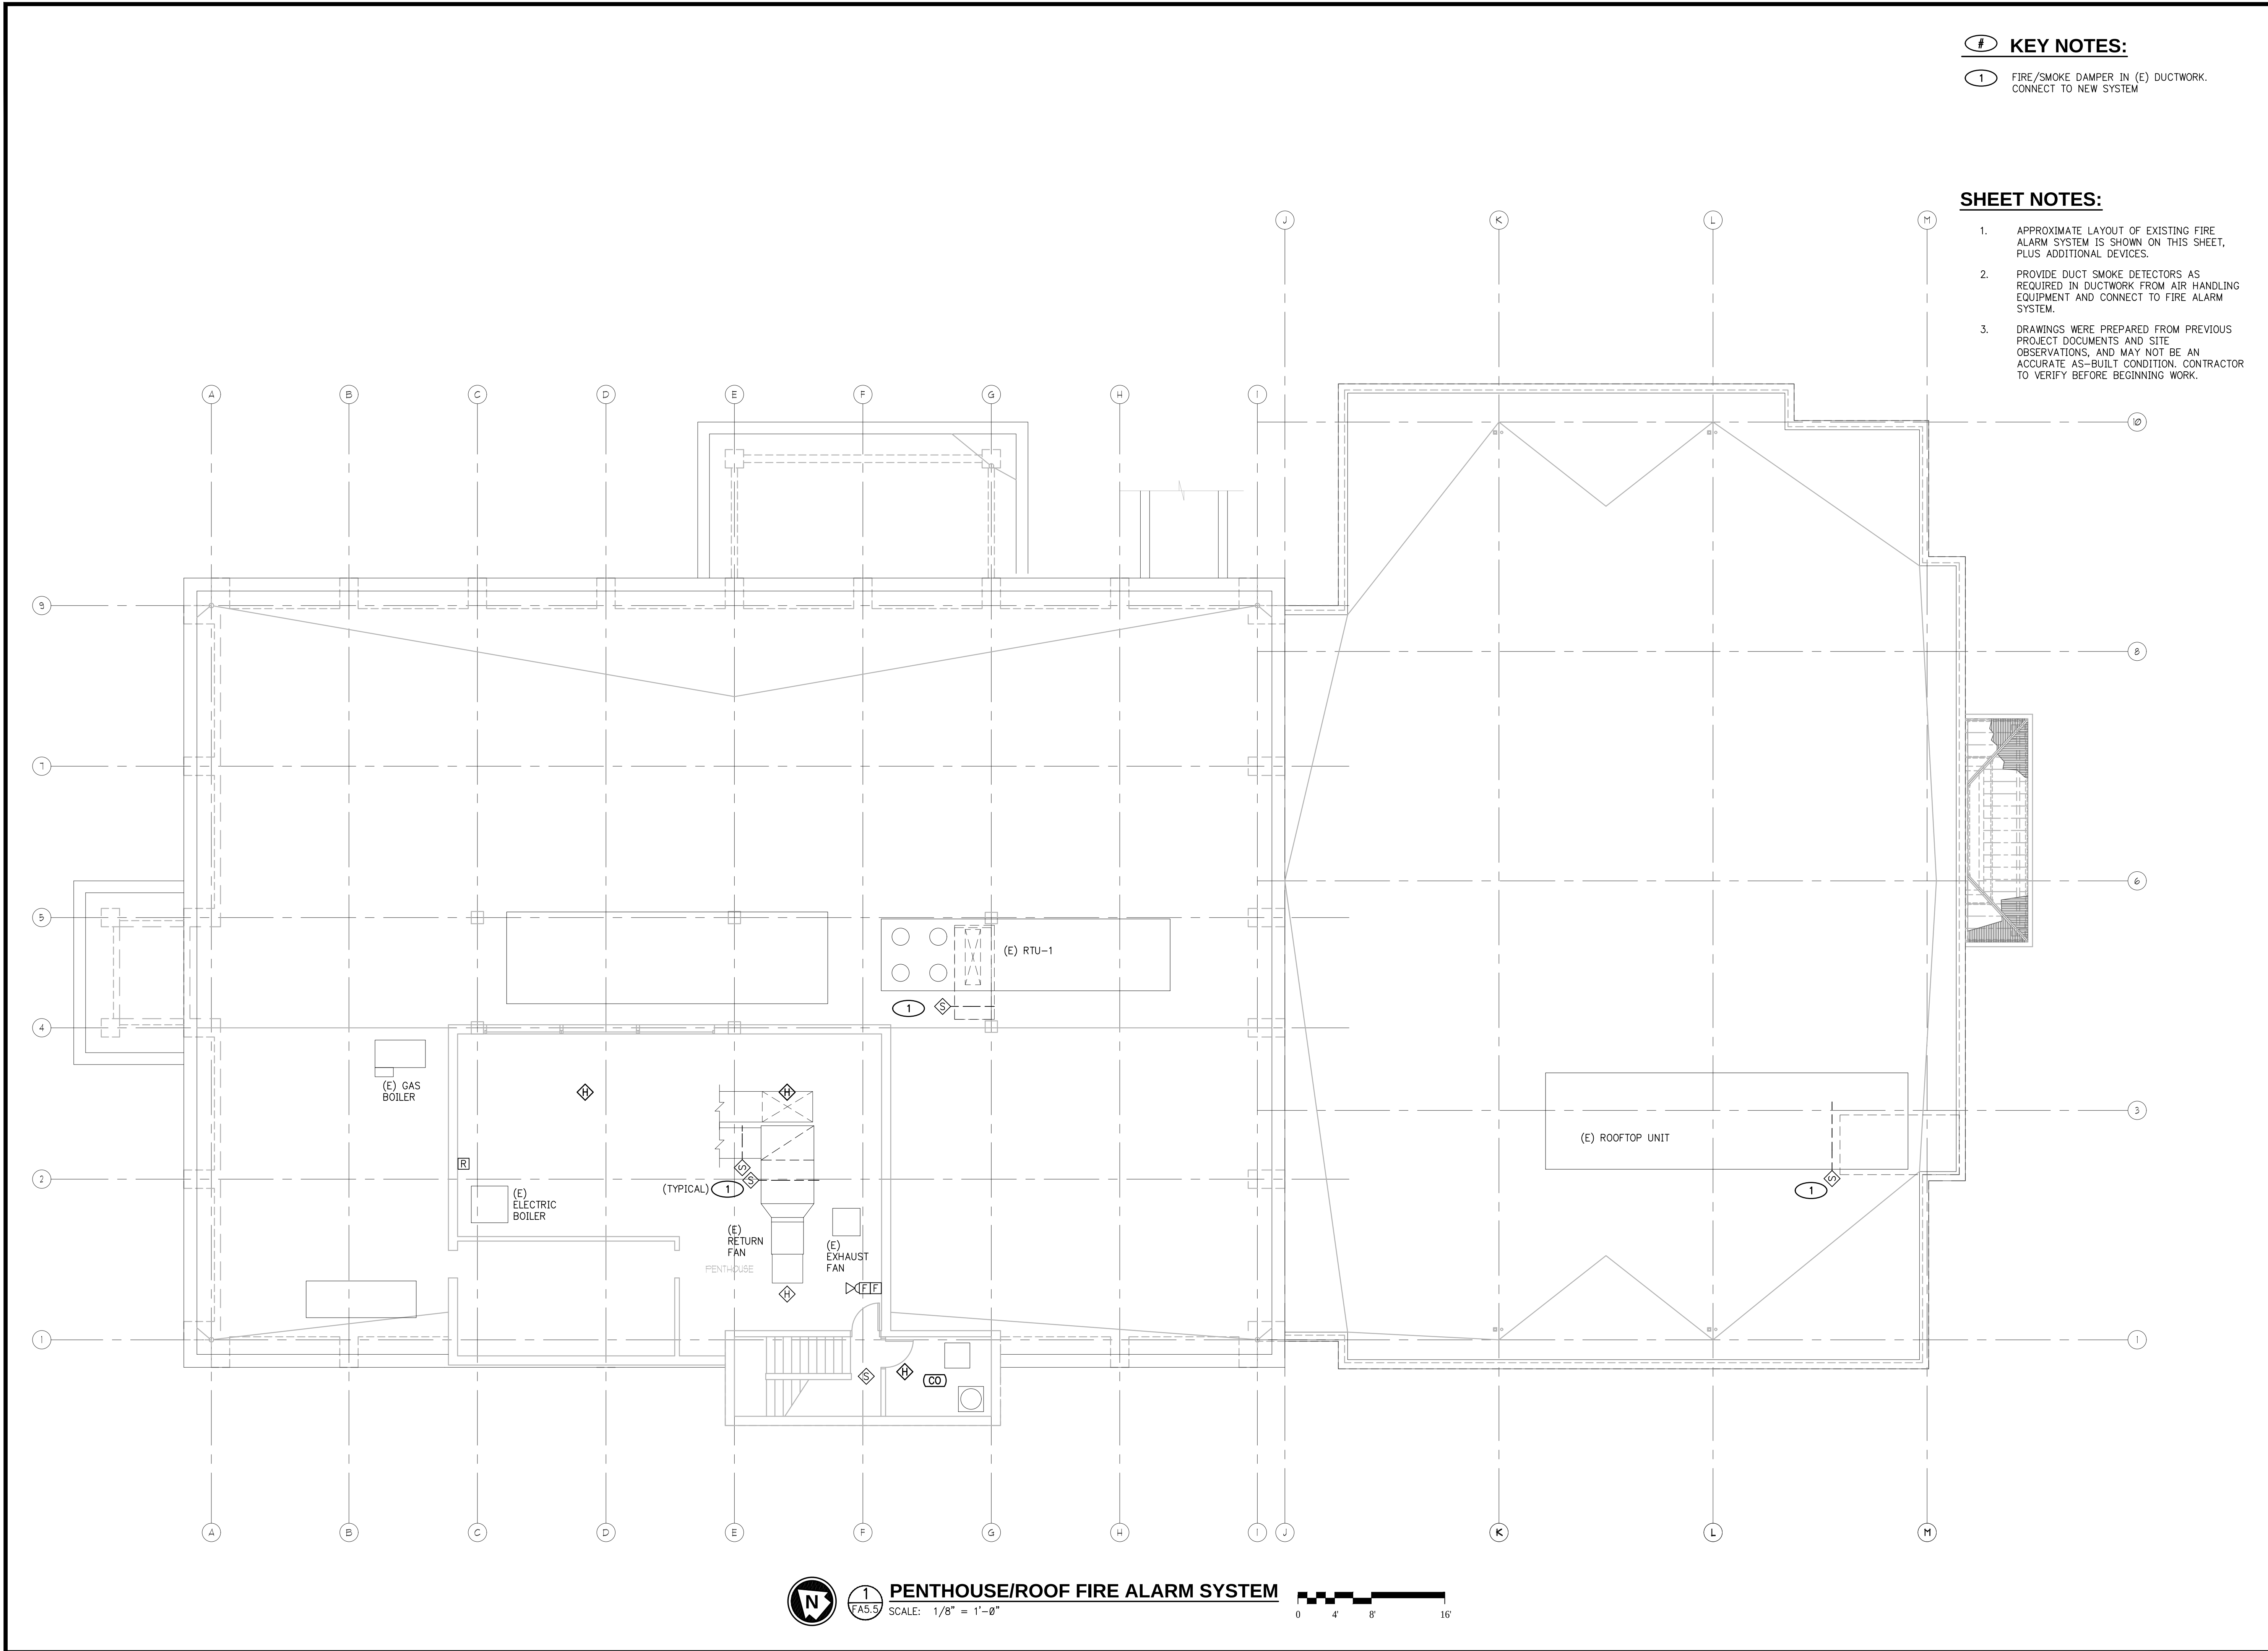

KEY NOTES:


- 1 FIRE/SMOKE DAMPER IN (E) DUCTWORK. CONNECT TO NEW SYSTEM

SHEET NOTES:

1. APPROXIMATE LAYOUT OF EXISTING FIRE ALARM SYSTEM IS SHOWN ON THIS SHEET, PLUS ADDITIONAL DEVICES.
2. PROVIDE DUCT SMOKE DETECTORS AS REQUIRED IN DUCTWORK FROM AIR HANDLING EQUIPMENT AND CONNECT TO FIRE ALARM SYSTEM.
3. DRAWINGS WERE PREPARED FROM PREVIOUS PROJECT DOCUMENTS AND SITE OBSERVATIONS, AND MAY NOT BE AN ACCURATE AS-BUILT CONDITION. CONTRACTOR TO VERIFY BEFORE BEGINNING WORK.

DESIGNED:	SCS
DRAWN:	TMP
DATE:	1/28/2021

PREPARED BY:

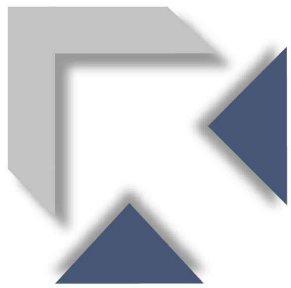

RICHMOND
ENGINEERING LLC
9721 GRIFFIN LANE SOUTHEAST
OLYMPIA, WA 98501
360.956.0364
WWW.RICHMONDSYSTEMS.COM



GEORGE M. RICHMOND
STATE OF WASHINGTON
20810
REGISTERED PROFESSIONAL ENGINEER

REVISION	DATE	BY	CK'D

SHEET CONTENTS:	PENTHOUSE/ROOF FIRE ALARM
PROJECT NO.:	5623
SHEET:	FA5.5

TITLE:

**LEWIS COUNTY
COURTHOUSE FIRE ALARM SYSTEM**

CHEHALIS, WA 98532